


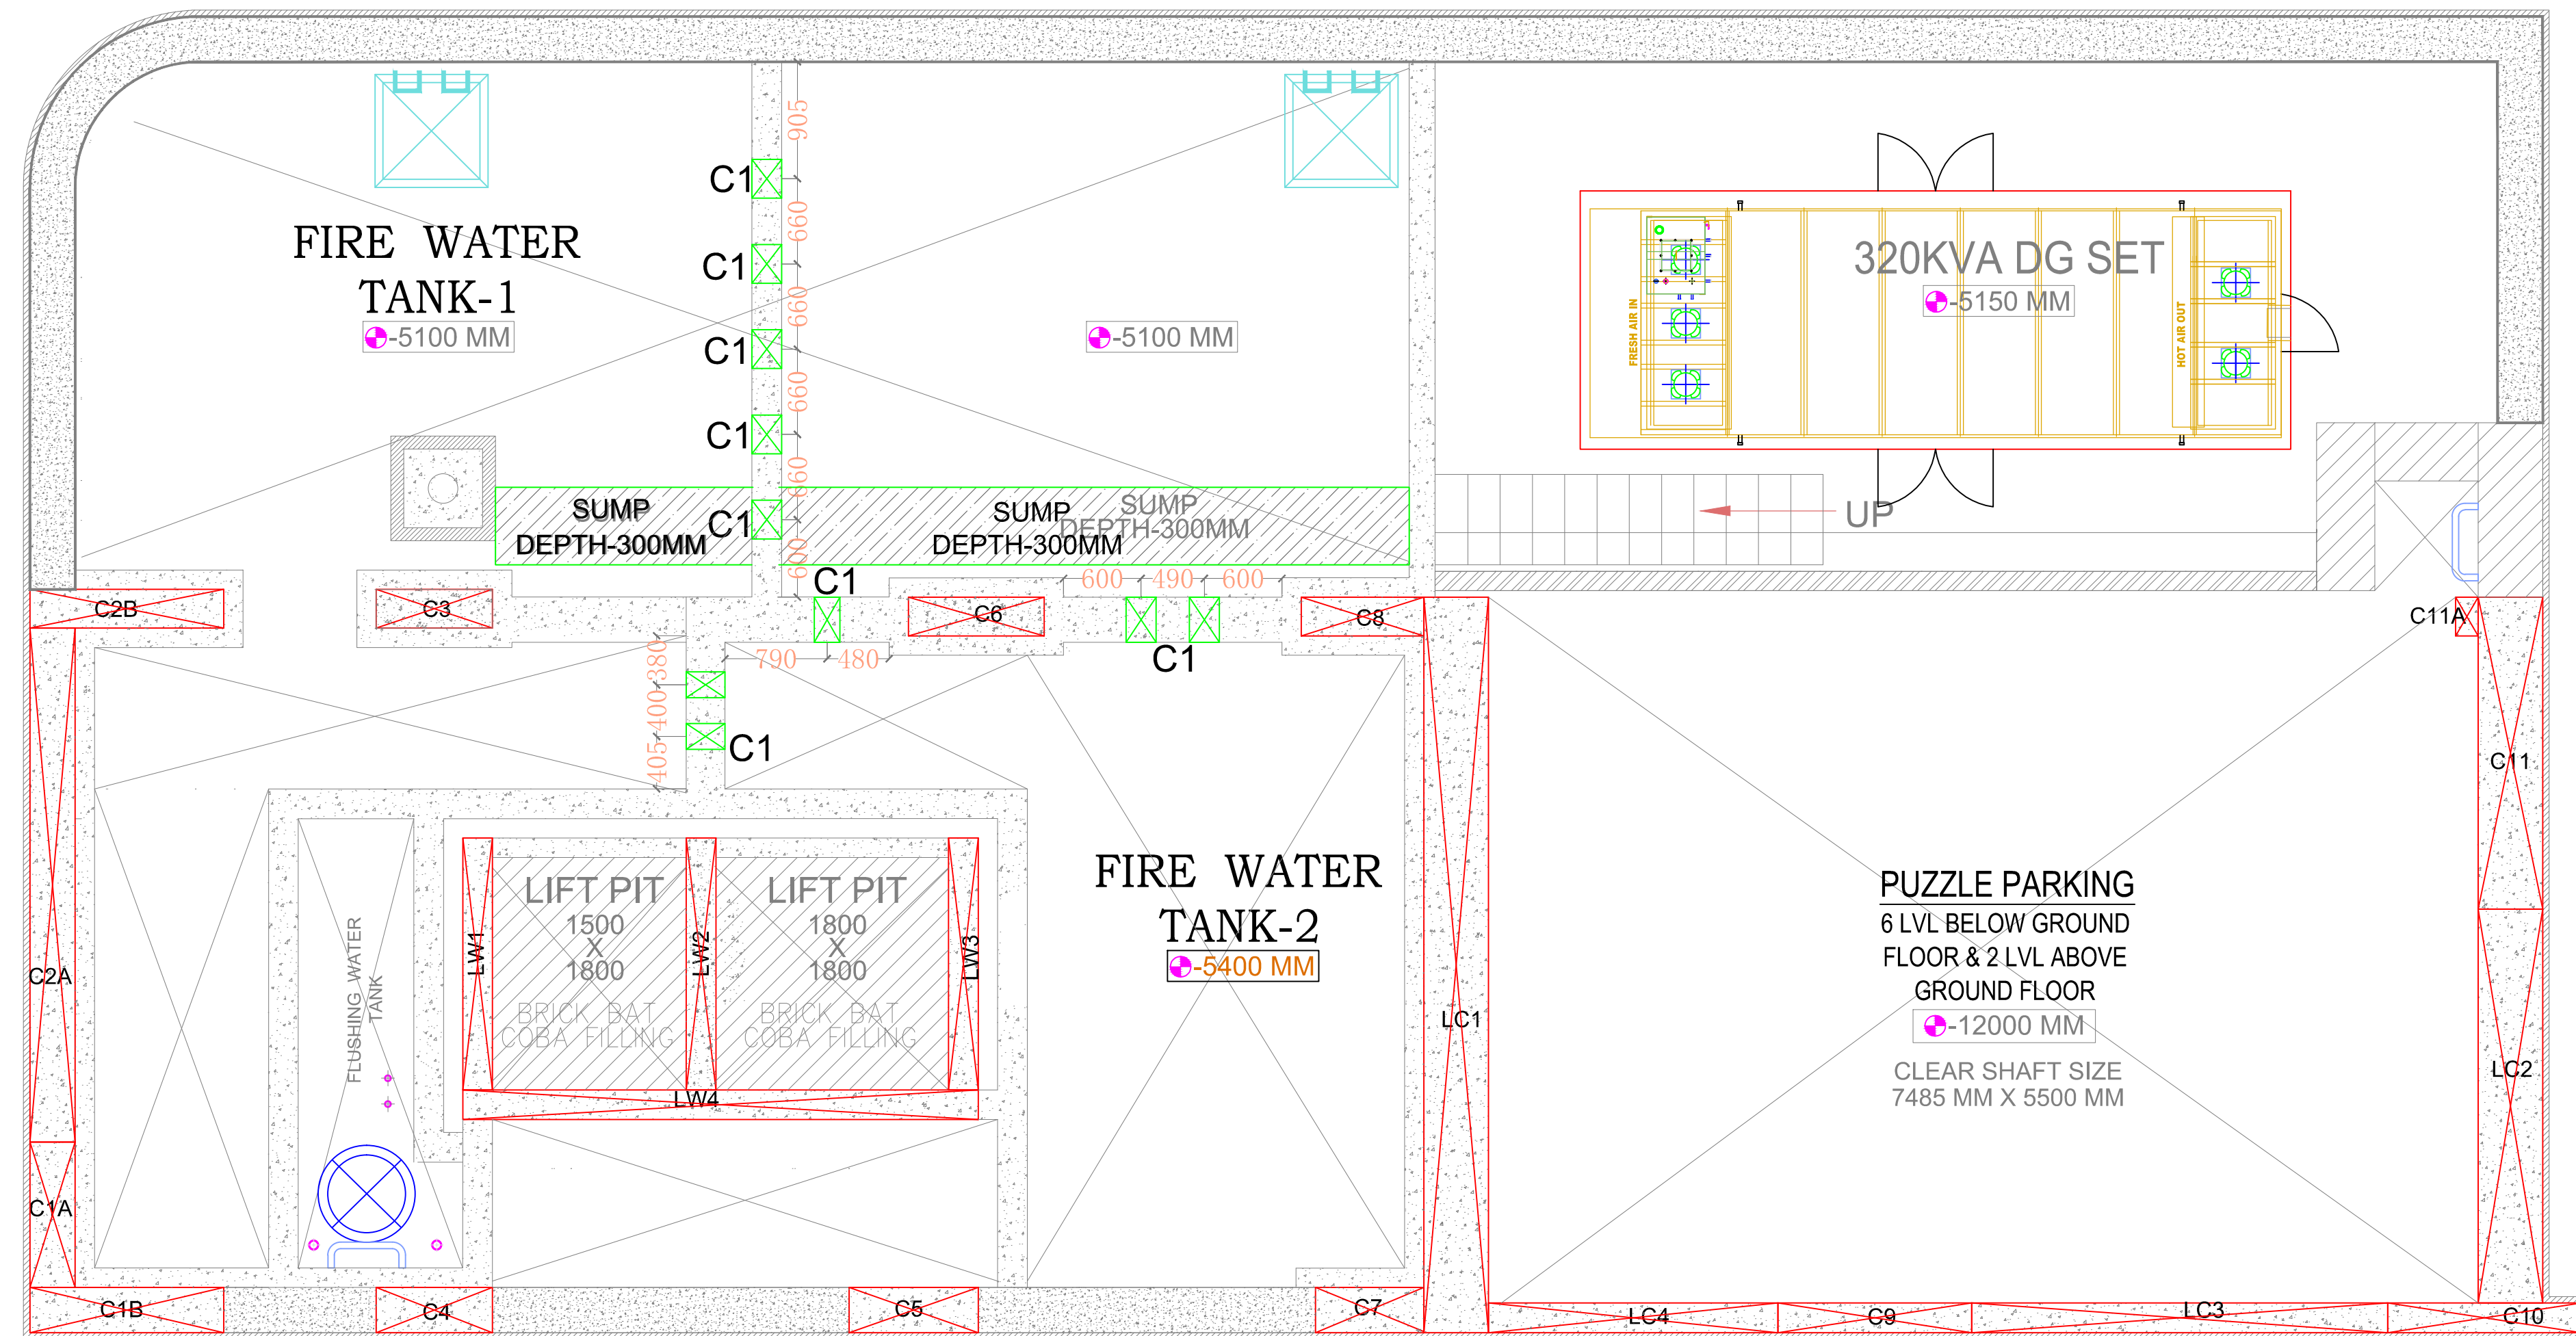

3 LOWER BASEMENT FLOOR PLAN

AT -5.4 M BELOW GROUND LVL

KEY PLAN


SCALE : NTS

NOTES:
1. ALL DIMENSIONS GIVEN ON THIS DRAWING ARE IN MILLIMETERS. DO NOT SCALE THE DRAWINGS, ANY DISCREPANCIES FOUND SHOULD BE REPORTED TO THE RESPONSIBLE ARCHITECT OR ENGINEER IMMEDIATELY.
2. IT IS THE RESPONSIBILITY OF THE CONTRACTOR OR TO ASCERTAIN AND CONFIRM THAT ALL DIMENSIONS SHOWN IN THESE DRAWINGS SHALL COMPLY WITH THE SITE DIMENSIONS AND LEVELS PRIOR TO PREPARING DRAWINGS AND EXECUTING THE WORKS.

LEGENDS:

R10	09.09.16	ISSUED FOR CONSTRUCTION	M.S.	M.S.
R9	09.09.16	ISSUED FOR CONSTRUCTION	M.S.	M.S.
R8	09.09.16	REVISED AS PER STRUCTURAL REQUIREMENT	M.S.	M.S.
R7	30.08.16	ISSUED FOR CONSTRUCTION	T.P.	P.K.
R6	16.03.16	ISSUED FOR CONSTRUCTION	T.P.	P.K.
R5	16.03.16	ISSUED FOR TENDER	T.P.	P.K.
R4	12.03.16	ISSUED FOR TENDER	T.P.	P.K.
R3	03.03.16	ISSUED FOR TENDER	T.P.	P.K.
R2	29.02.16	ISSUED FOR TENDER	T.P.	P.K.
R1	20.02.16	ISSUED FOR TENDER	T.P.	P.K.
R0	06.02.16	ISSUED FOR TENDER	T.P.	P.K.

REV.	DATE	DESCRIPTION	DRN	CHKD.

RELEASED FOR
☐ PRELIMINAR ☐ APPROVAL ☐ TENDER ☒ CONSTRUCTION

CLIENT:

Mr. HUKUMRAJ MEHTA

PROJECT :
HUKAMRAJ MEHTA (MEHTA RESIDENCY)
PROPOSED C.S. NO.335/6,
SCHEME NO.6, ROAD NO.2,
SION HSG CO. OP. SOCIETY, PLOT NO.35,
FOR:- SION EAST MUMBAI, 400022.

PMC :

ARCHITECT:


MEP SERVICES CONSULTANT:

ELECTRO-MECH CONSULTANTS PVT LTD
106/1ST Floor, Siddharth Dargah, Dada Patil wadi,
Thane(West) 400 602, Maharashtra, India.
Tel : +91-022 6510 3097/2538 /9671
Email : emc.mumbai@gmail.com/www.electromech.co.in

TITLE: LOWER BASEMENT FLOOR PLAN SERVICES LAYOUT		NORTH  SHEET SIZE: A0
DRG No. EMC-PL-542-02	JOB No. 542	REVISION R10
DRAWN TANAJI	DATE 06.02.2016	SCALE 1:000
CHKD. PRAKASH	APP. PRAKASH	